



ELEVATION A - A - COMBUSTION TURBINE
DRAWING GA-2

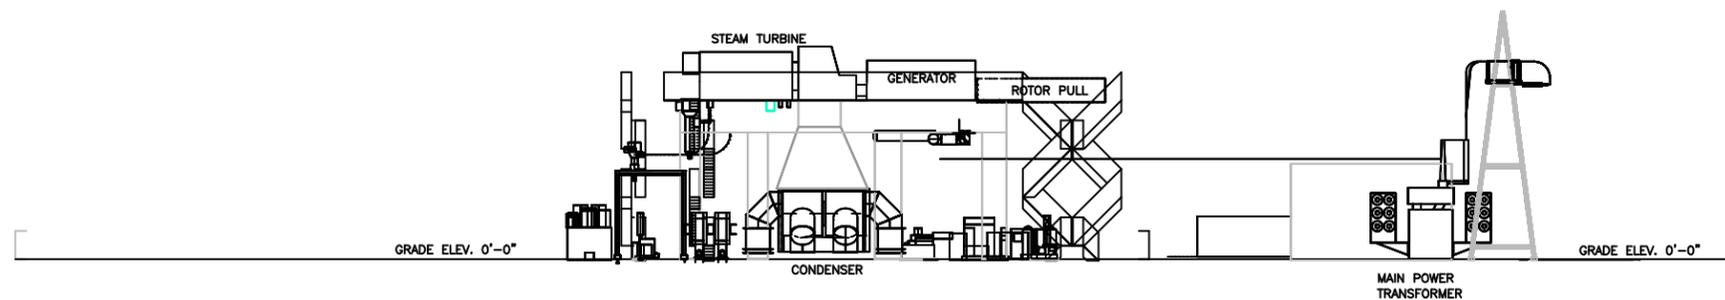

ELEVATION B - B - STEAM TURBINE
DRAWING GA-2

NOTE:
PREVIOUSLY PRINTS HAD BEEN SUBMITTED
FOR PERMITTING WERE STAMPED WITH
ENGINEER'S SEAL & SIGNED.

 PRELIMINARY
NOT FOR CONSTRUCTION



DRAWING RELEASE RECORD						DRAWING RELEASE RECORD						SCALE	PROJECT NUMBER	GENERAL ARRANGEMENT ELEVATIONS UMATILLA COMBINED CYCLE POWER PLANT	PG&E NATIONAL ENERGY GROUP	DRAWING NO. FIGURE 2-6A	REV. 3
REV.	DATE REL'D.	PREPARED	REVIEWED	APPROVED	PURPOSE	REV.	DATE REL'D.	PREPARED	REVIEWED	APPROVED	PURPOSE						
						1	10/10/00	G.R. KUJAWA	S.L. WAHLERT	K.T. KOSTAL	ISSUED FOR PROPOSAL	16'	10955-000				
						2	12/18/00	G.R. KUJAWA	S.L. WAHLERT	K.T. KOSTAL	ISSUED FOR PROPOSAL	0'					
						3	12/26/00	G.R. KUJAWA	S.L. WAHLERT	K.T. KOSTAL	ISSUED FOR PROPOSAL	16'					
												32'					